

Copyright
 This drawing and any design here on is the copyright of the Consultants and must not be reproduced without their written consent.
 All drawings remain the property of the Consultants.

THIS DRAWING TO BE READ IN CONJUNCTION WITH ALL RELEVANT ARCHITECTS AND ENGINEERS DRAWINGS.

FIGURED DIMENSIONS ONLY TO BE TAKEN FROM THIS DRAWING.

ALL LEVELS ARE IN METRES AND RELATE TO DATUM AT MALIN HEAD.

THIS DRAWING IS REPRODUCED FROM DIGITAL MAPS:
 O.S. MAPS - Scale 1:2,500
 O.S. MAPS - Scale 1:1,000
 DISCOVERY SERIES - Scale 1:50,000

ALL MAPS ARE REFERENCED TO IRISH NATIONAL GRID (I.T.M.)


REPRODUCED FROM THE ORDNANCE SURVEY OF IRELAND BY PERMISSION OF THE GOVERNMENT. LICENSE NO. 3-3-34.

THIS DRAWING IS A COPY OF AN ELECTRONIC FILE AND IS COPYRIGHT.


ALL DIMENSIONS TO BE CHECKED ON SITE.

ALL MATERIALS AND WORKMANSHIP TO BE IN ACCORDANCE WITH ENGINEERS SPECIFICATION.


IT IS THE CONTRACTORS RESPONSIBILITY TO VERIFY ALL DIMENSIONS AND LEVELS PRIOR TO COMMENCEMENT OF CONSTRUCTION.

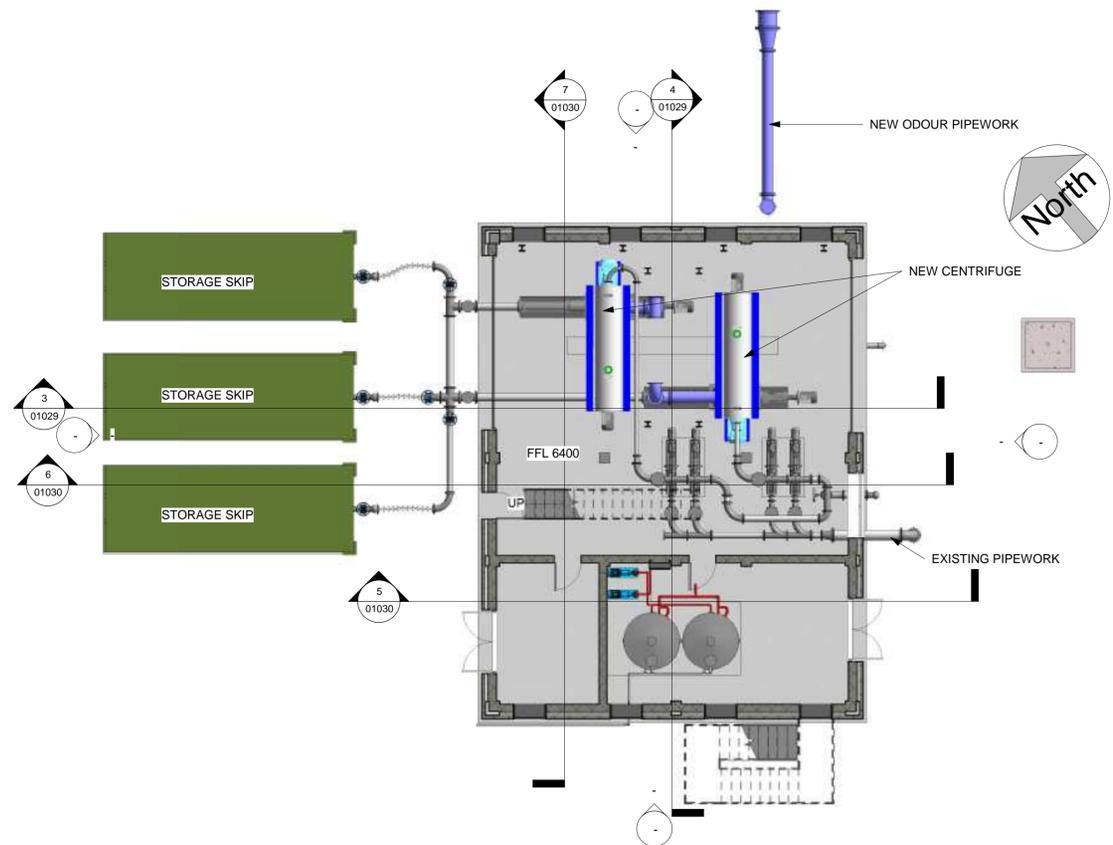


1 Ground Floor Plan
 1 : 100

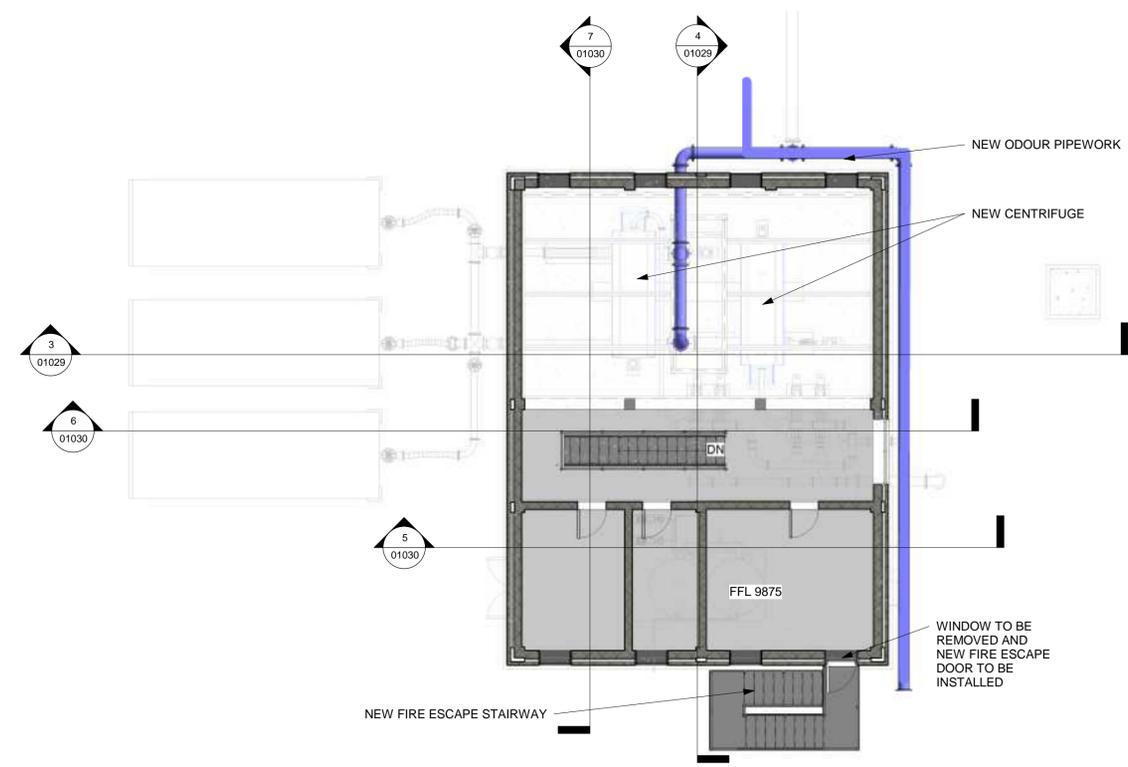

2 Second Floor Plan
 1 : 100

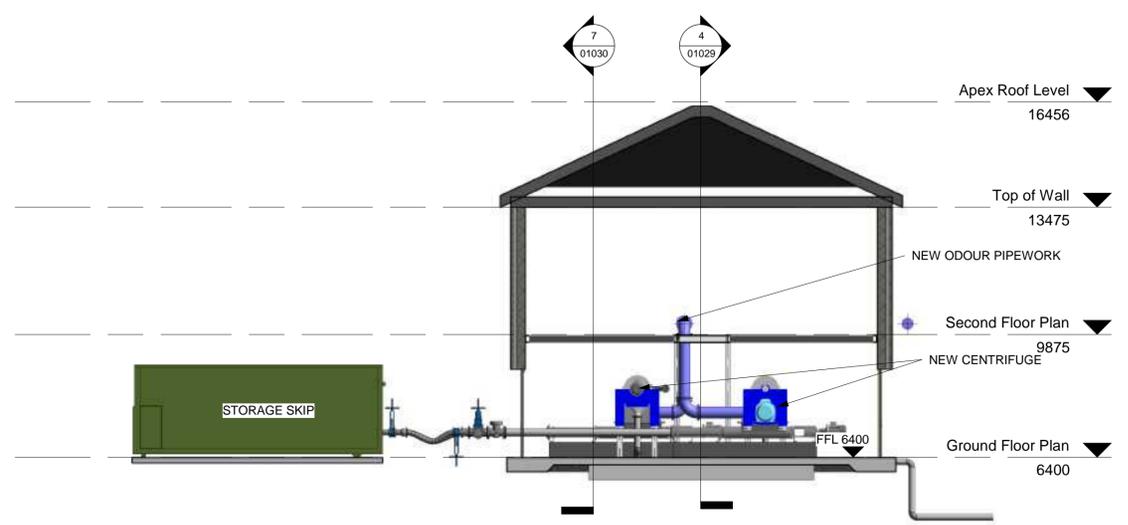

3 Section 1
 1 : 100

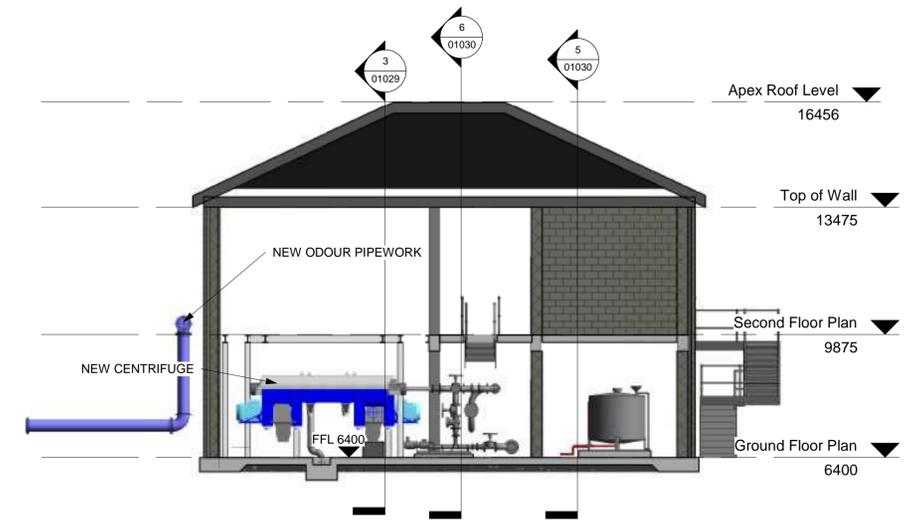

4 Section 2
 1 : 100

C01	A1	ISSUED FOR PLANNING	PJ	28-02-23
Rev:	Suit:	Revision Description	Checked:	Date:

Client:
UISCE EIREANN IRISH WATER
 Colville House
 24-26 Talbot St
 Dublin 1
 Tel: 1890 276 278
 Tel: +353-1-707 2828
 Email: info@water.ie
 Web: www.water.ie

Project:
CASTLETROY WASTEWATER TREATMENT PLANT

Clients Representative:
J. B. Barry and Partners Limited Consulting Engineers
 Classon House
 Dundrum Business Park
 Dundrum Road
 Dublin 14
 Tel: +353 1 485 1400
 Email: info@jbbarry.ie
 Web: www.jbbarry.ie

Drawn By:	LHA	Date:	06/12/22
Checked By:	PH	Date:	06/12/22
Approved by:	PJ	Date:	06/12/22
Internal Project No.	20701-JBB-00-XX-DR-Z	Stage	PLANNING

Drawing Title:
MODIFICATIONS TO EXISTING DEWATERING HOUSE PLAN LAYOUTS AND SECTIONS

Scales: 1 : 100

Drawing No.	Sheet No.	Revision:	Suitability:
20701-JBB-00-XX-DR-Z	01029	C01	

O:20 Projects\20701 - Castletroy WwTP (Case 2-4100-WPP\Planning Drawings\FEB-2023\20701-LBB-00-XX-DR-Z-01029-01030-Existing Sludge Dewatering Plant House.rvt